


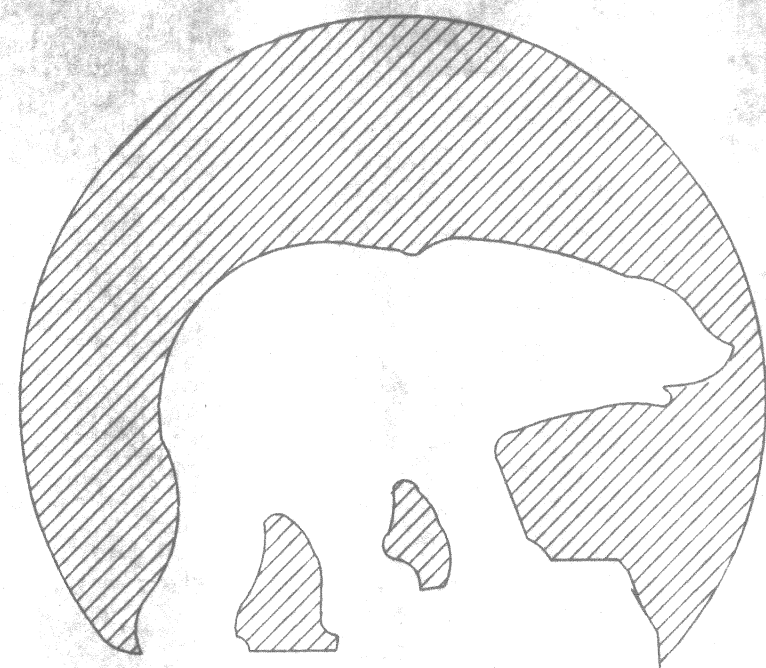

Northwest
Territories Canada


DEPARTMENT OF PUBLIC WORKS

HAMLET OF KUGLUKTUK
WATER SUPPLY
IMPROVMENTS

CIVIL PACKAGE - ISSUED FOR TENDER

LIST OF DRAWINGS

- | | |
|-----|--|
| C-1 | BASE SITE PLAN FOR WATER STORAGE RESERVOIR |
| C-2 | RESERVOIR PLAN AND SECTION, FENCE DETAILS. |

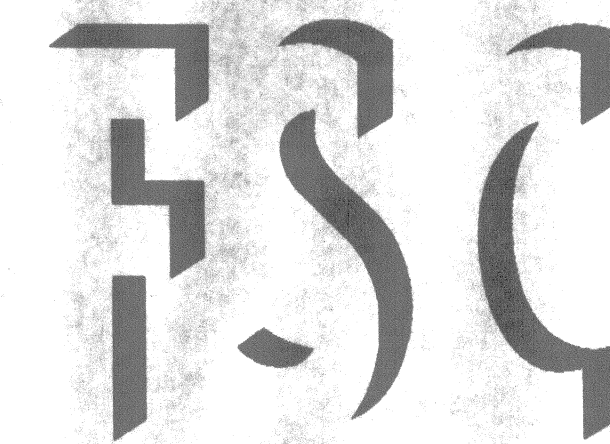

G R O U P

FERGUSON SIMEK CLARK


ENGINEERS AND ARCHITECTS

4910 - 53rd Street, P.O. Box 1777
Yellowknife, N.W.T. Canada
X1A 2S4

D.P.W. PROJECT NO. 6-602
MARCH 25, 1999

TENDER SET _____


FSC PROJECT NO. 97-0170

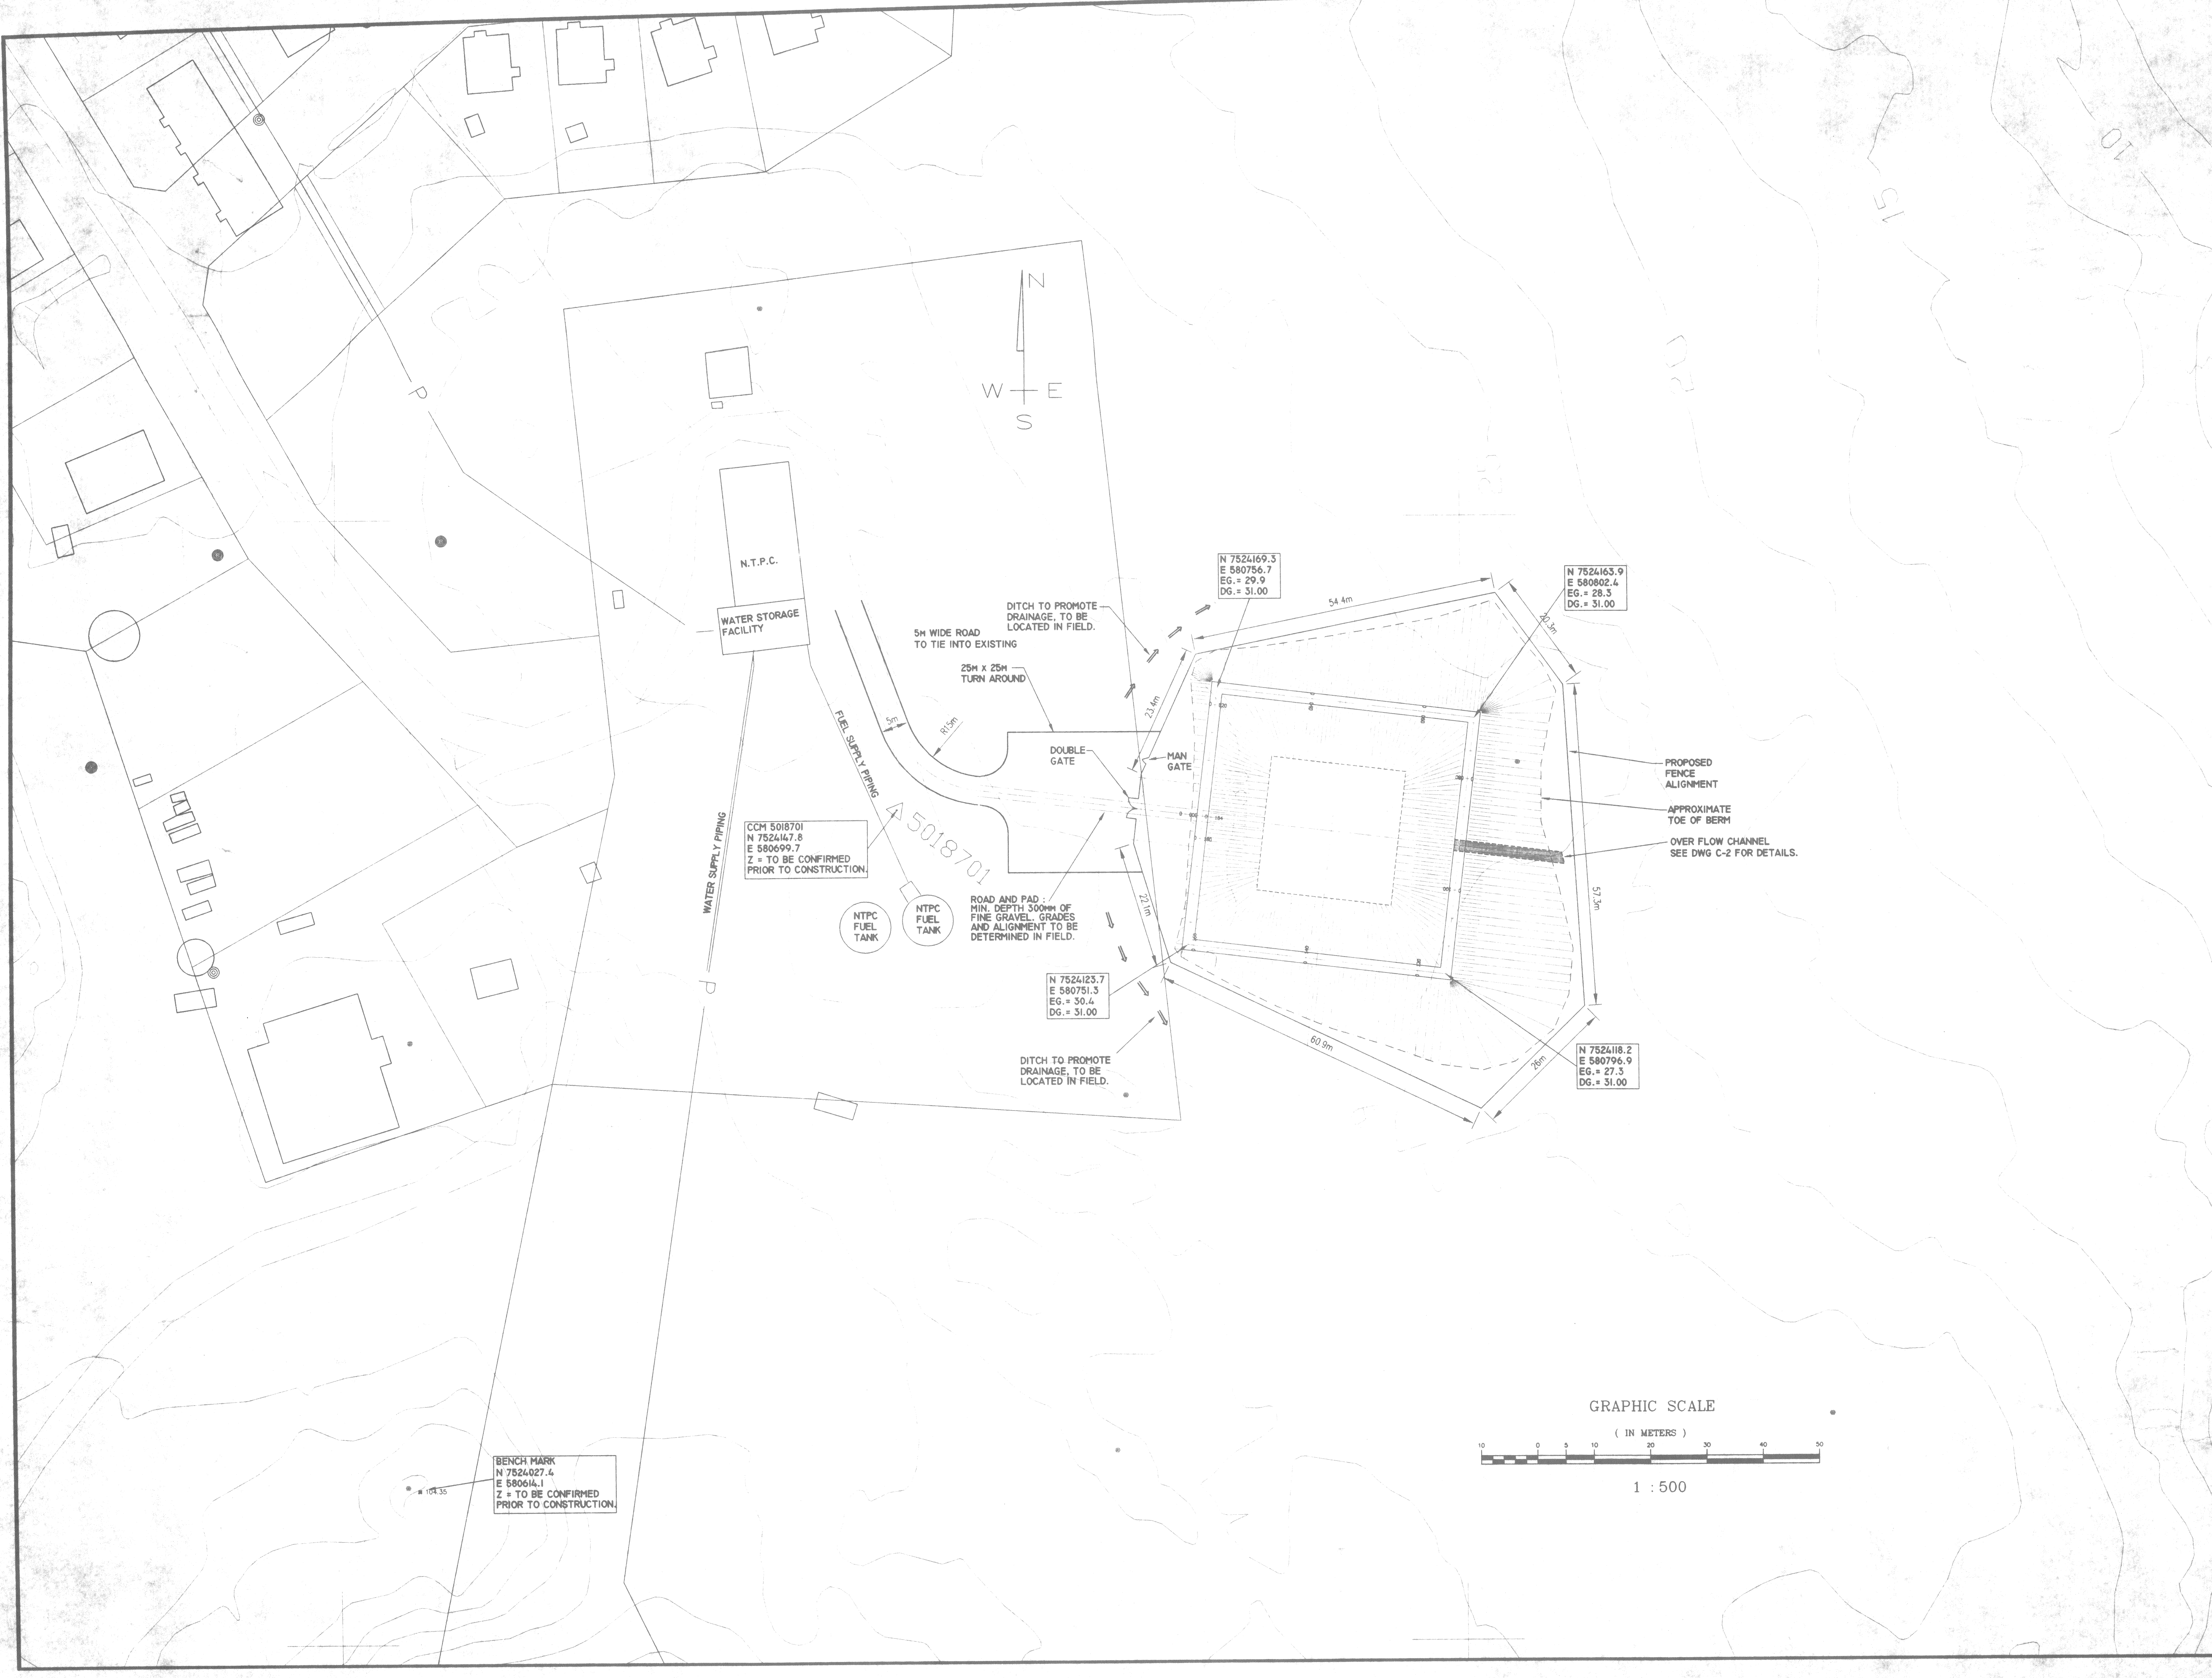

LEGEND	
N 7524169.3 E 580756.7 EG = 29.9 DG = 31.00	NORTHING EASTING EXISTING GRADE DESIGN GRADE

NOTE:
CONTOURS AT 2.5 METRE INTERVAL
FENCE DIMENSIONS SHOWN ARE
APPROXIMATE.

THE ASSOCIATION OF
PROFESSIONAL ENGINEERS,
GEOLOGISTS and GEOPHYSICISTS
OF THE NORTHWEST TERRITORIES
PERMIT NUMBER
P 003
FERGUSON SIMEK
CLARK

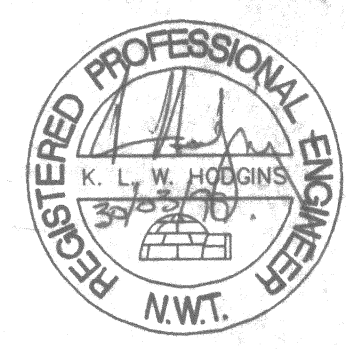

NO	REVISION	DATE	BY	APP'D
2	ISSUED FOR TENDER	MAR 25/99		
1	ISSUED FOR REVIEW	FEB 15/99		











DEPARTMENT OF PUBLIC WORKS

JOB TITLE
**KUGLUKTUK WATER
SUPPLY IMPROVEMENTS**

KUGLUKTUK N.W.T.

DRAWING TITLE
**BASE SITE PLAN
WATER STORAGE
RESERVOIR**

DESIGNED BY KH/DK	SCALE 1:500
DRAWN BY DK/KK	DATE MAR. 26/99
CHECKED BY KH	CLIENT PROJECT NO.
F.S.C. FILE NO. BASEPLAN.DWG	F.S.C. JOB NO. 97-0170
SHEET	DRAWING NO. C-1

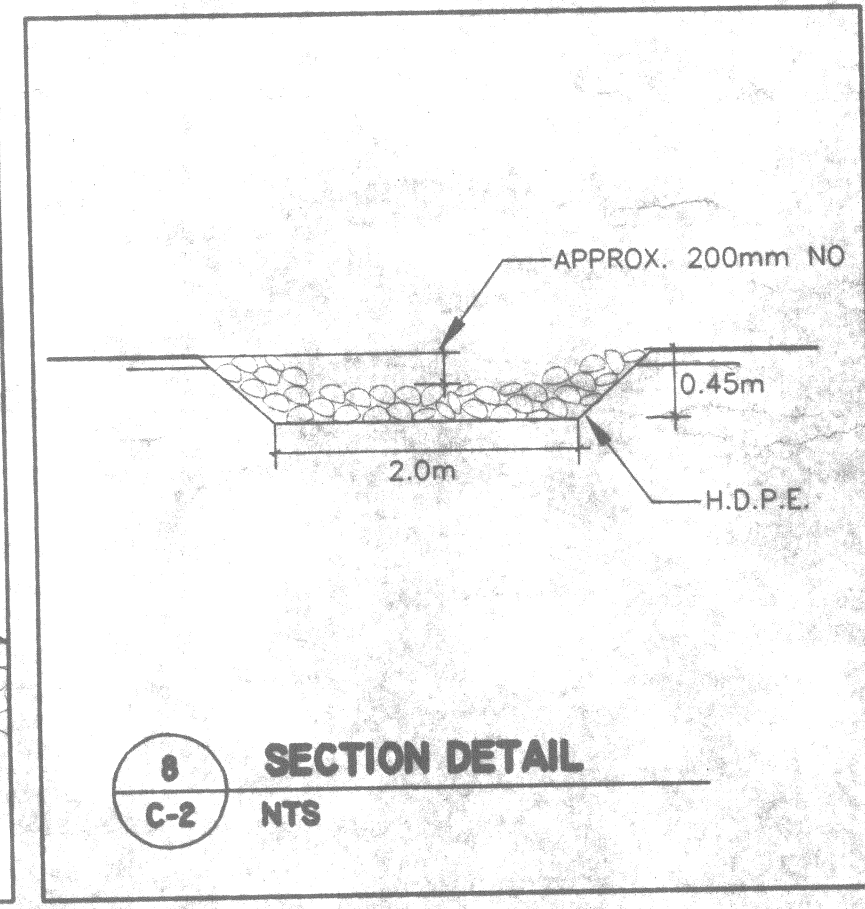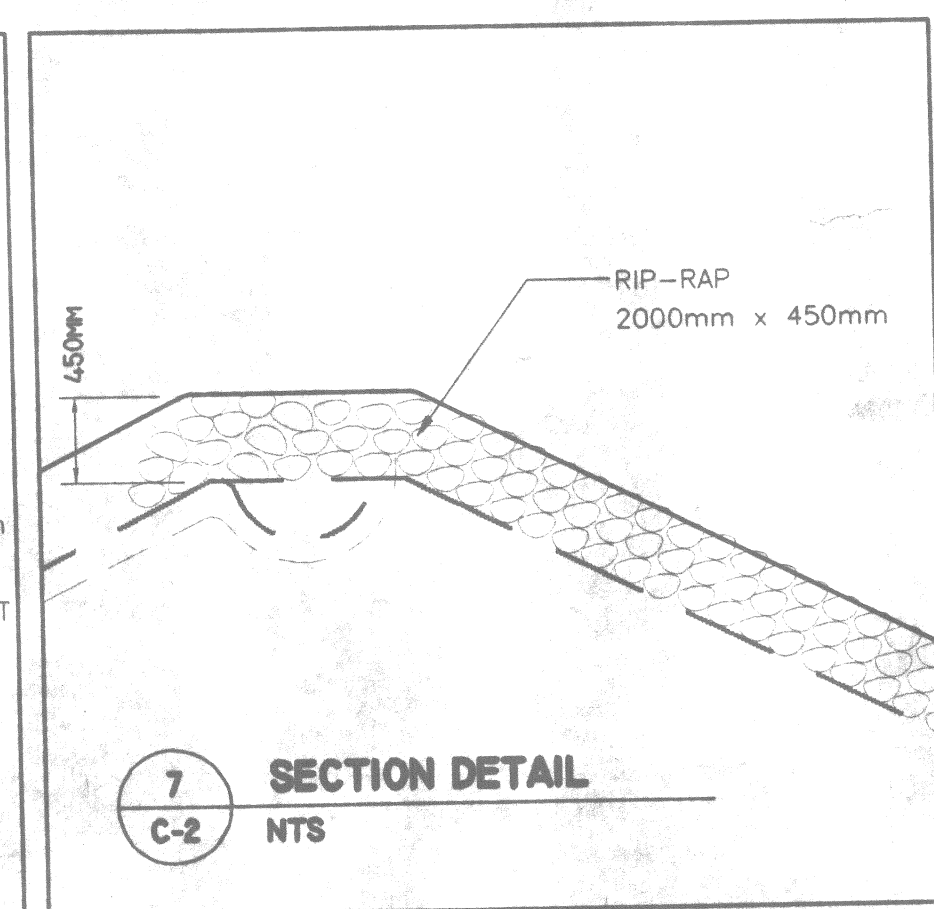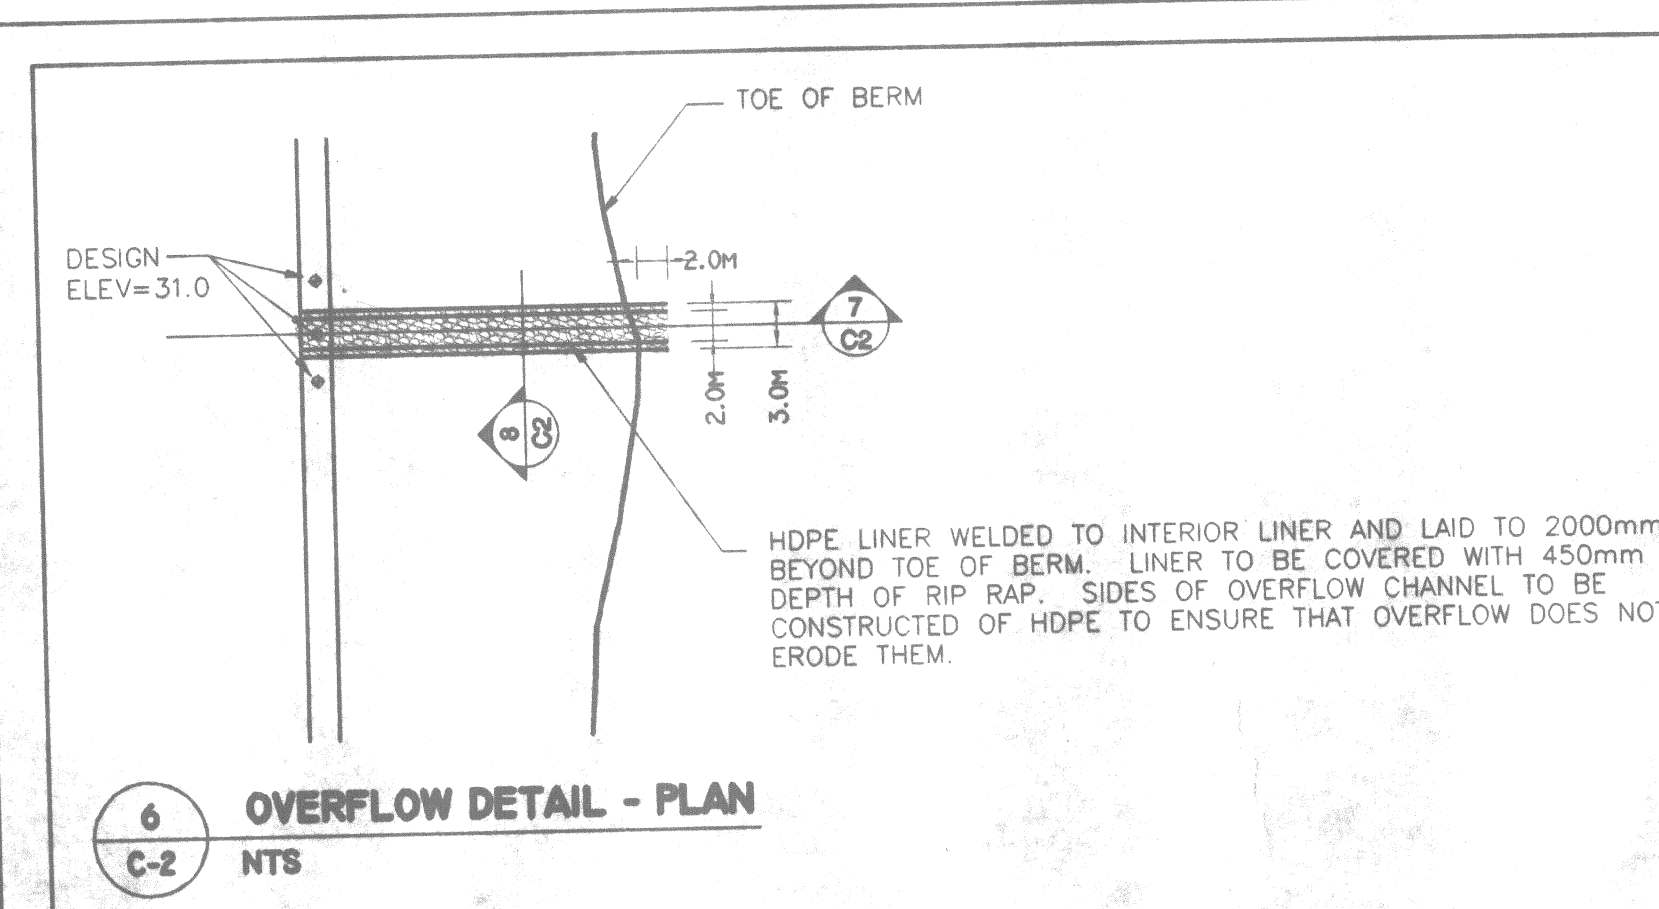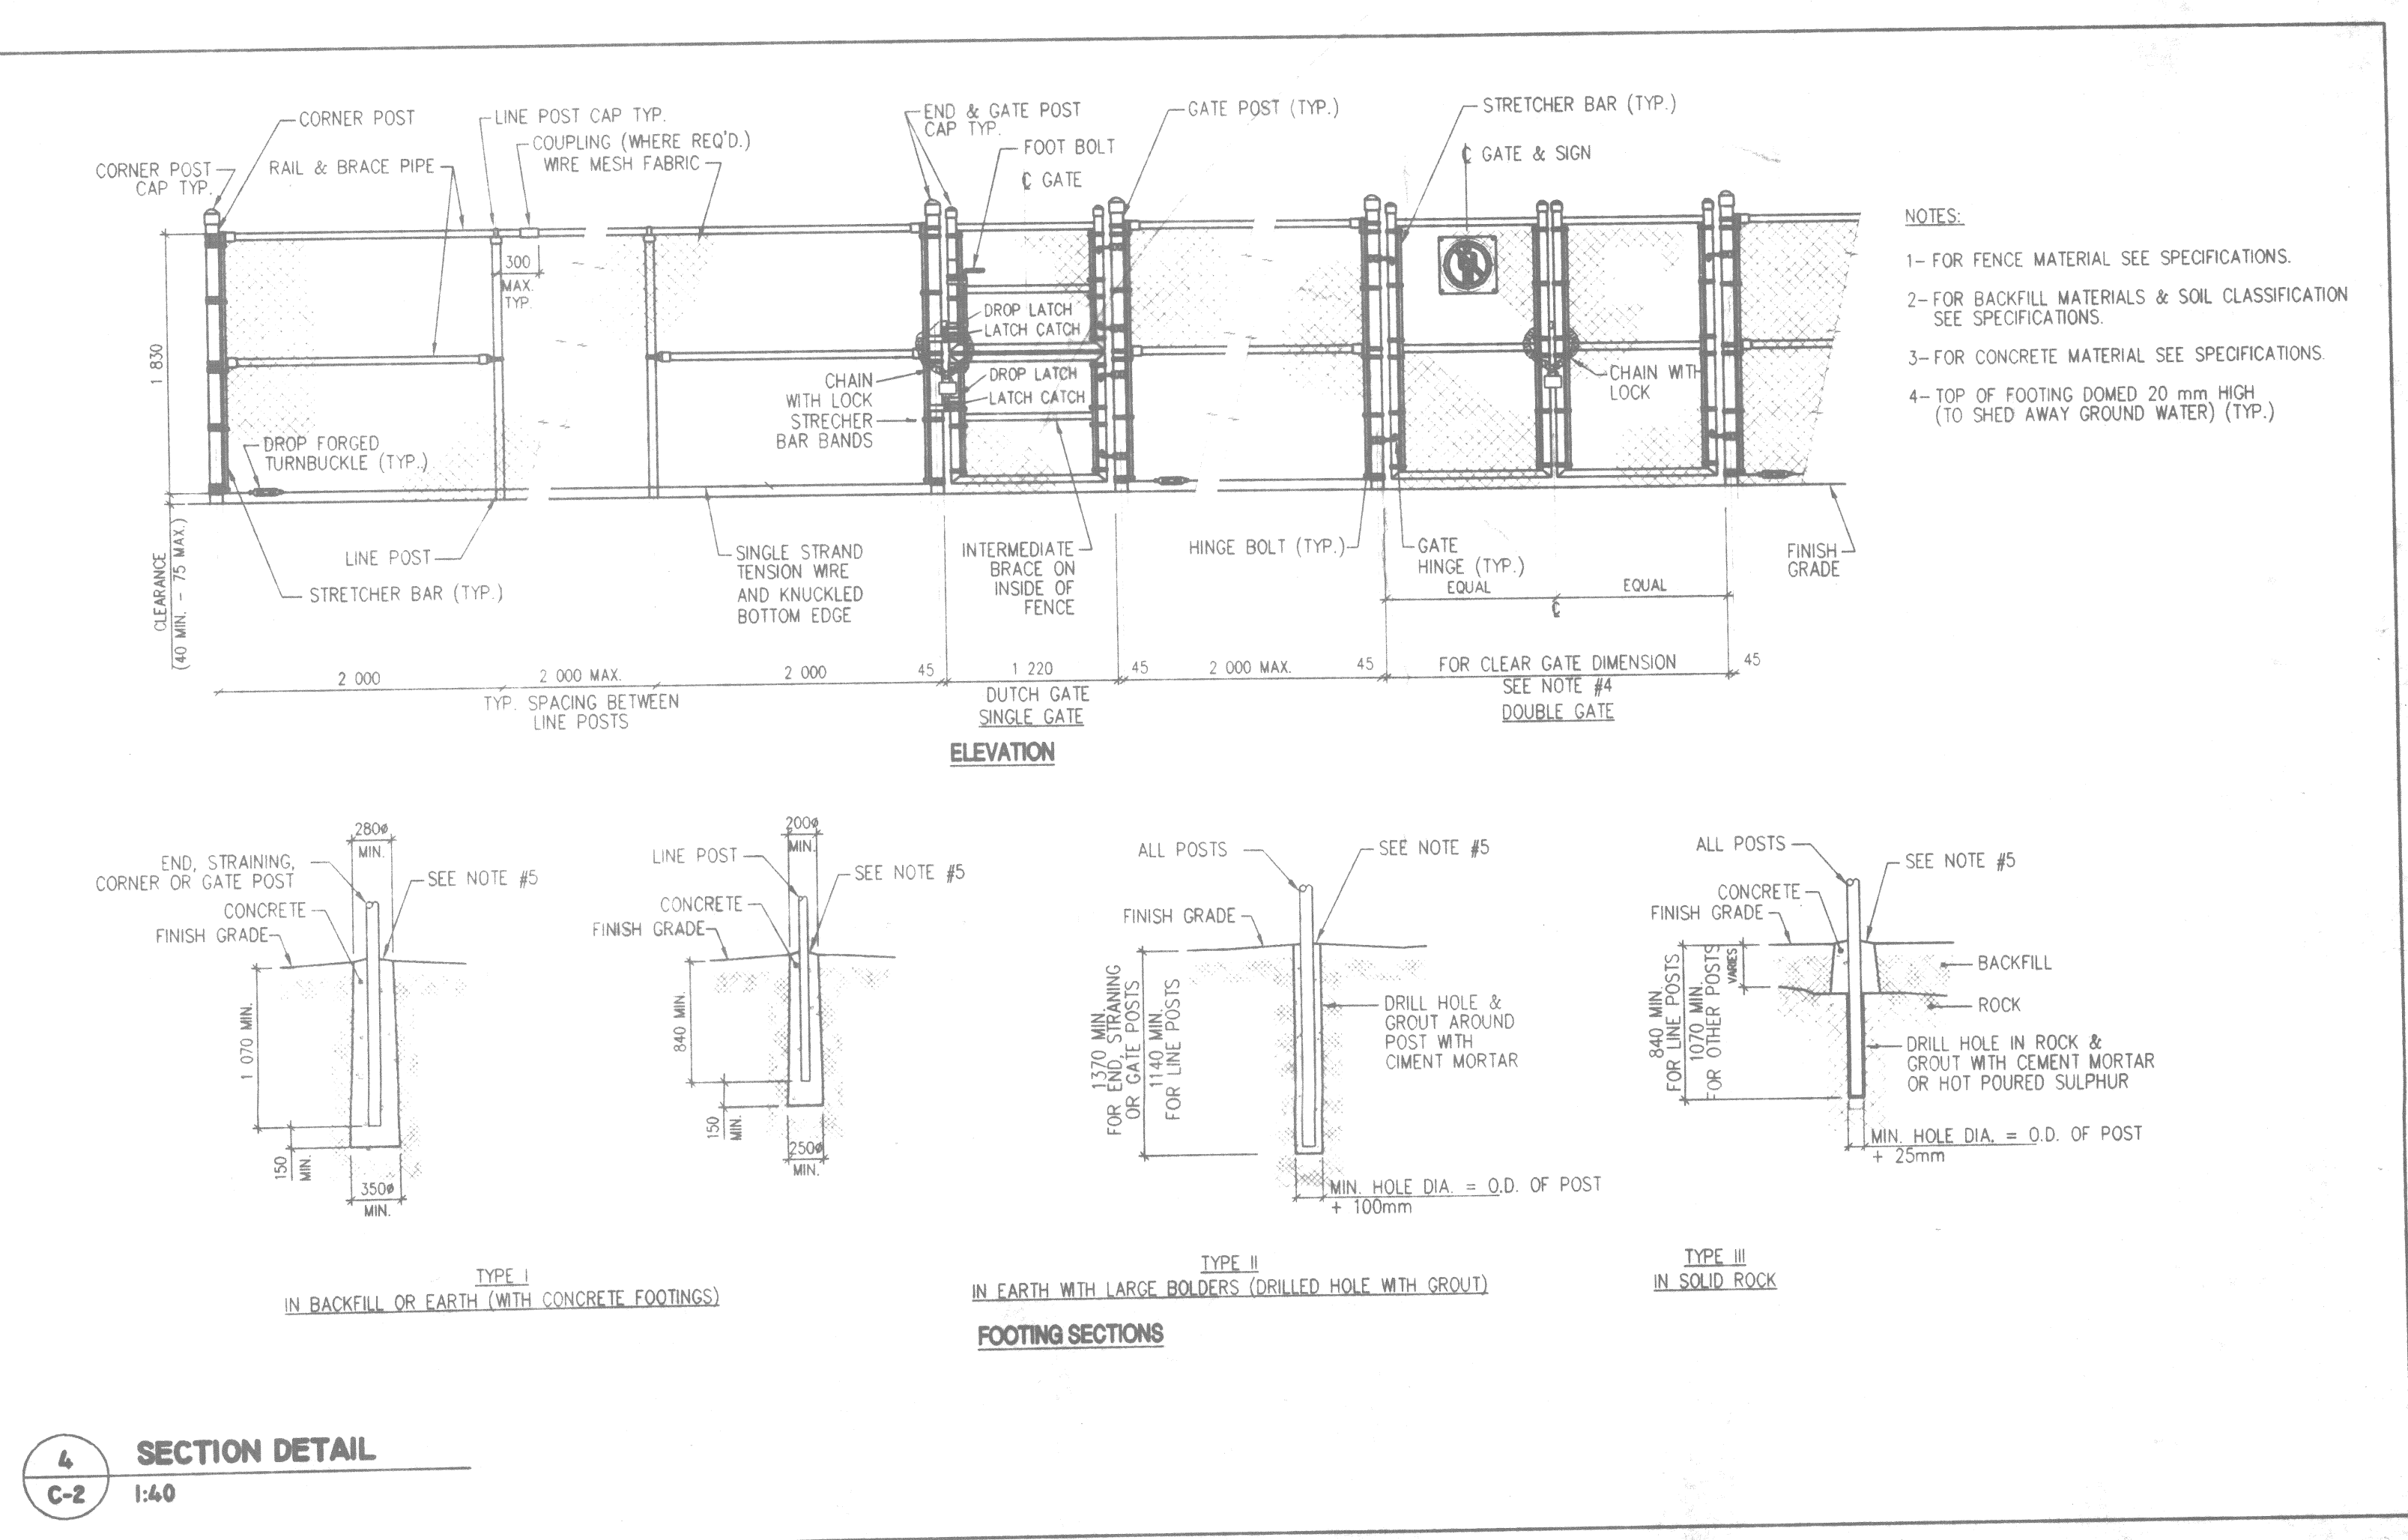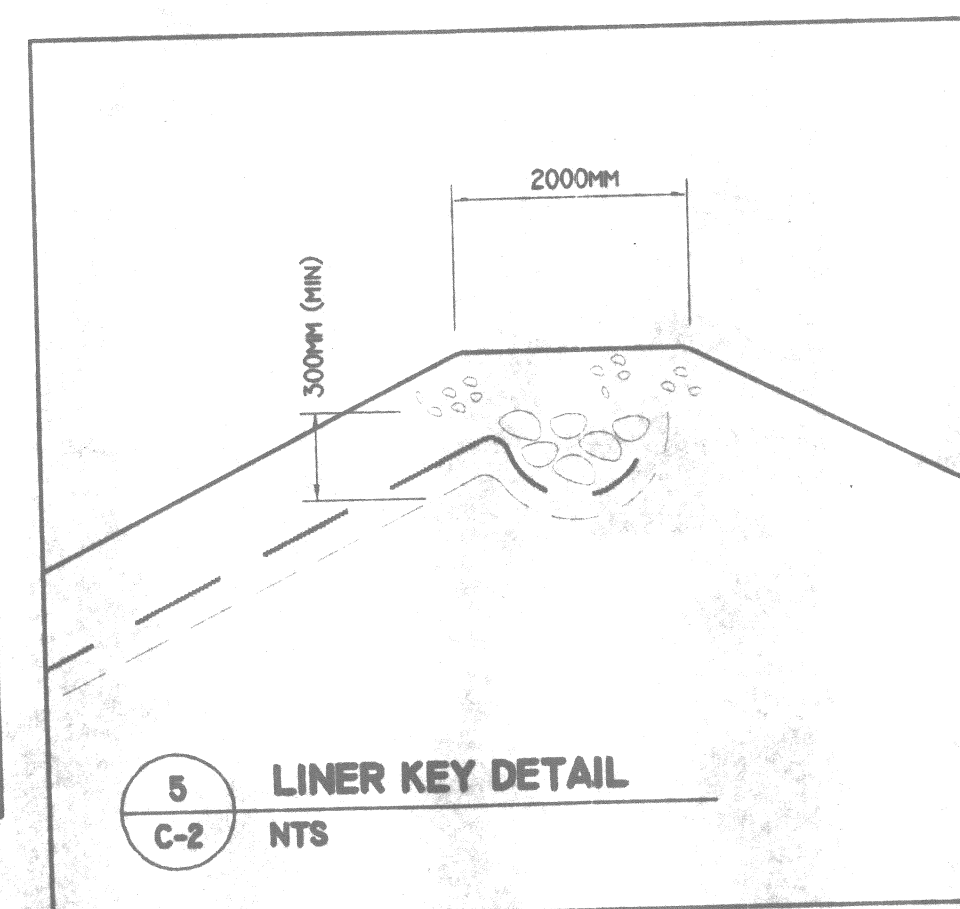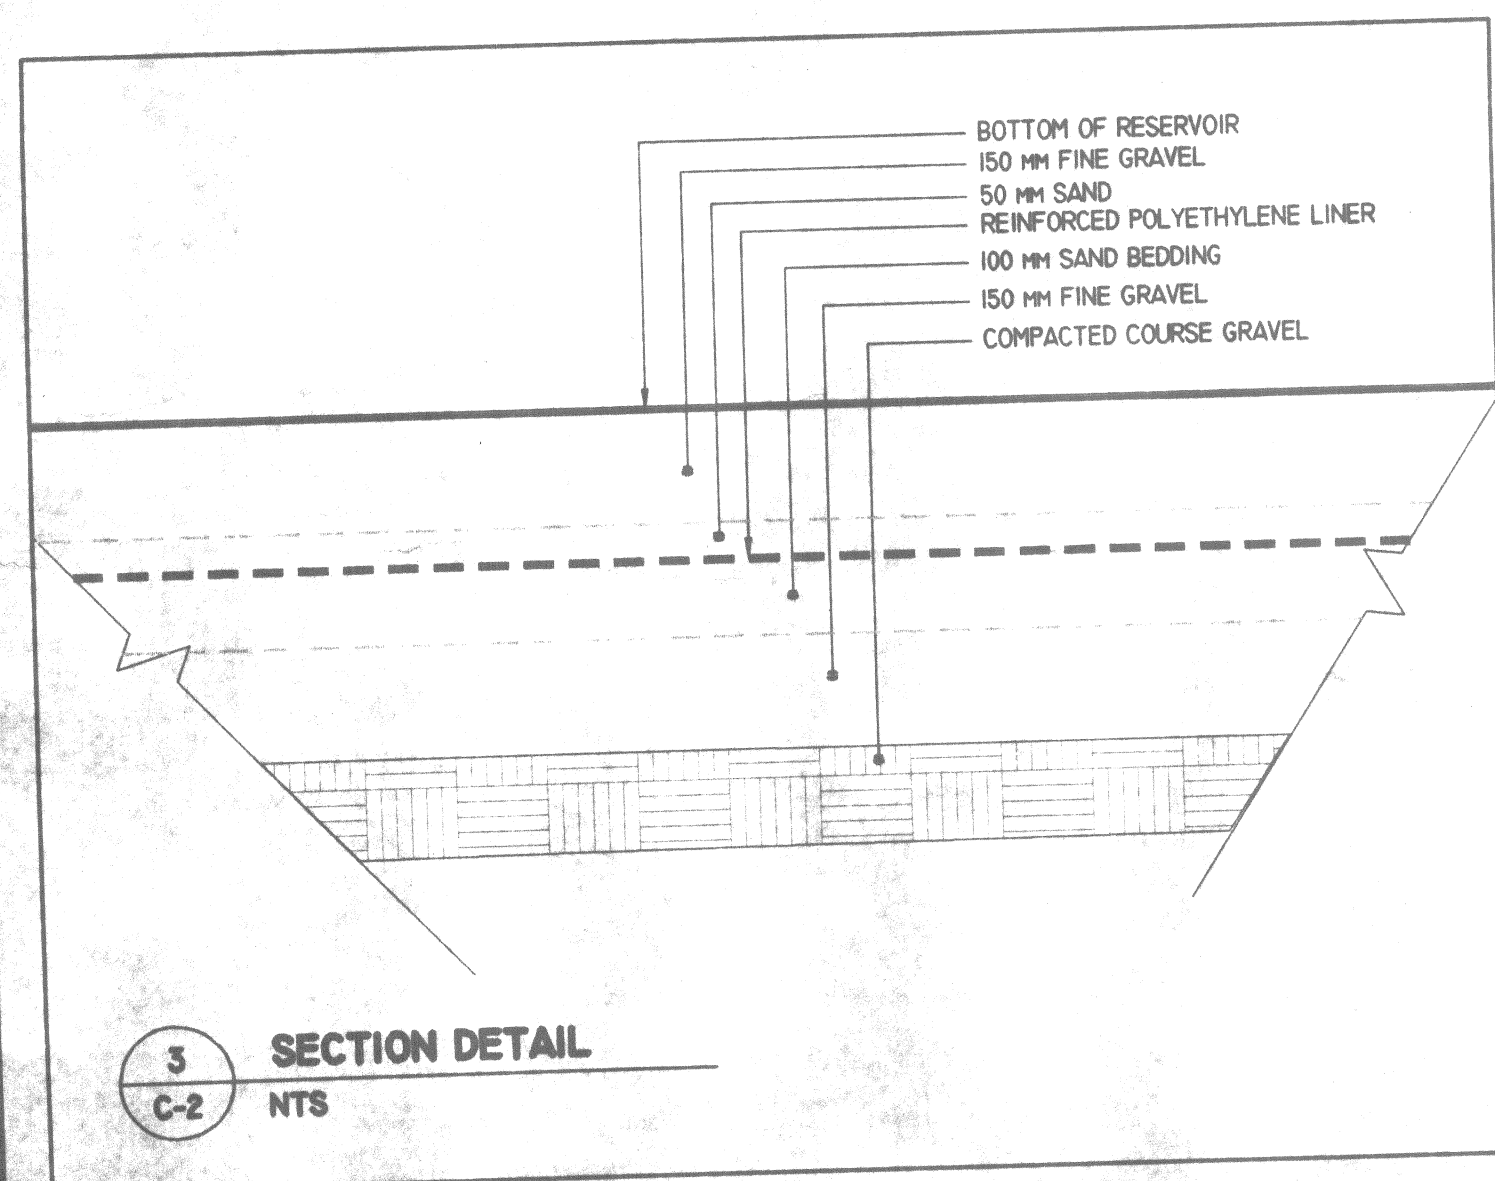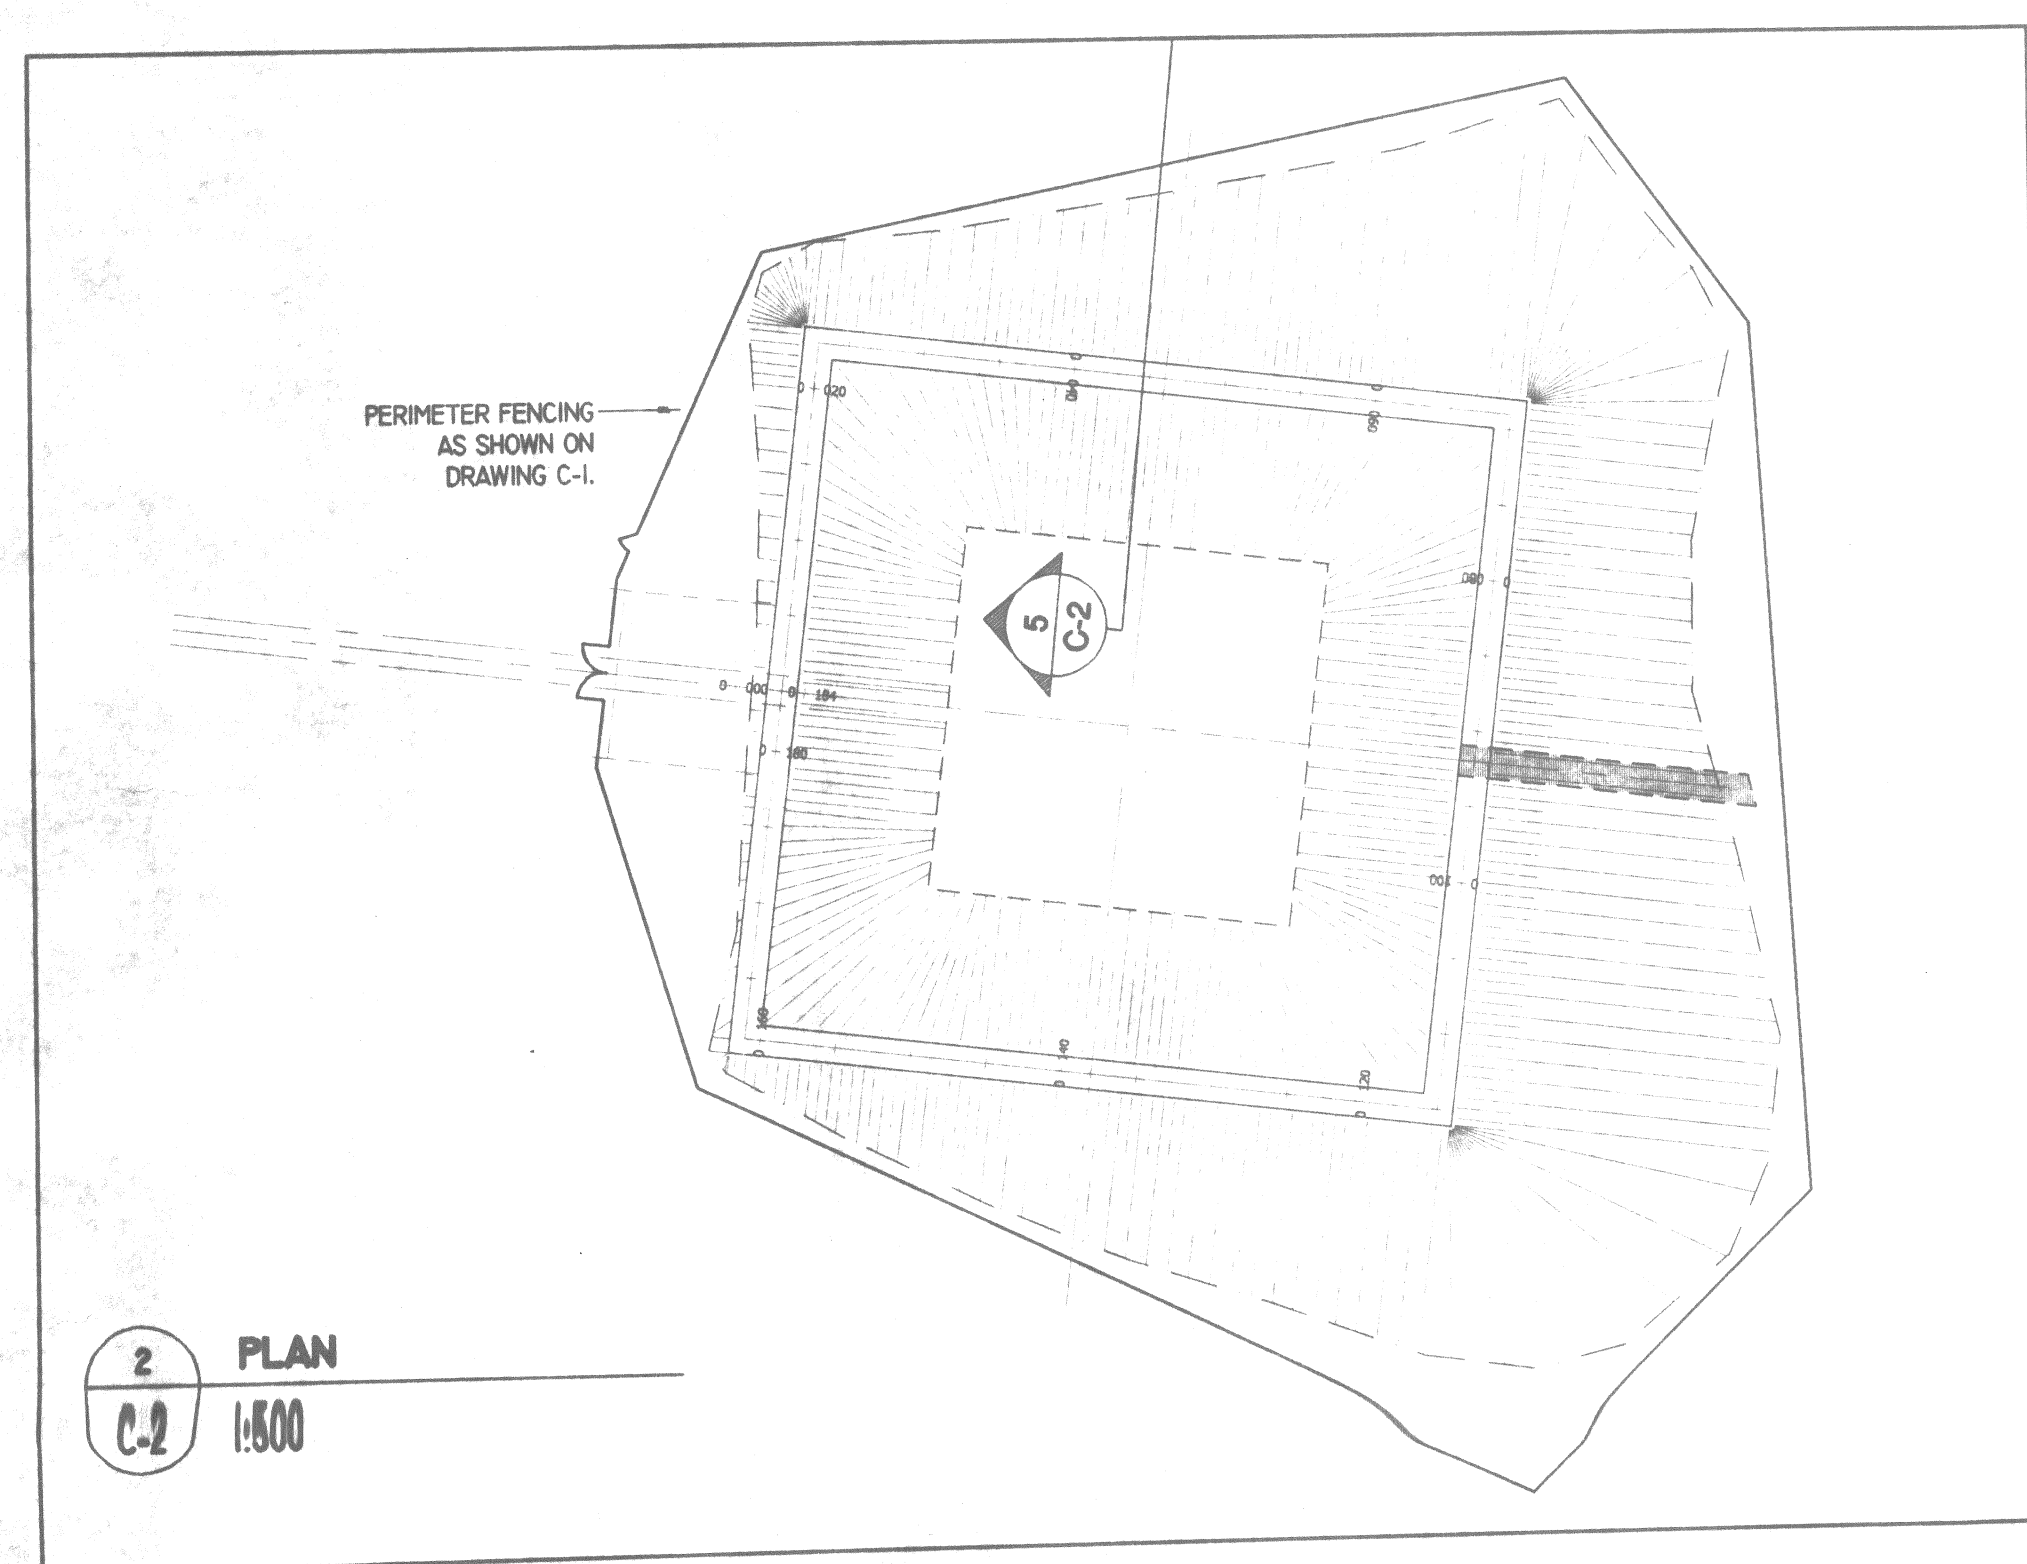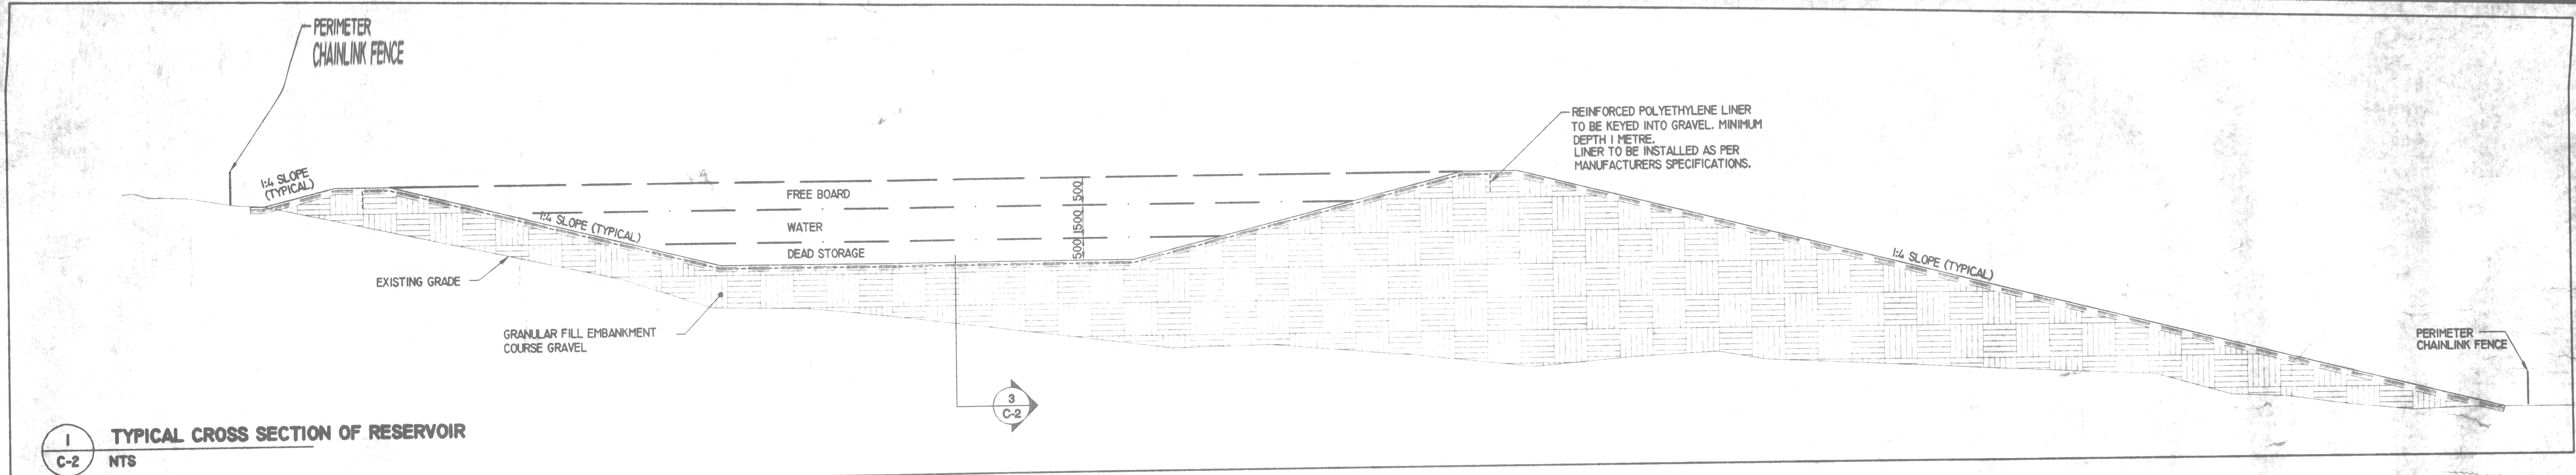

2	ISSUED FOR TENDER	MAR. 25/99
1	ISSUED FOR REVIEW	FEB. 15/99
NO.	REVISION	DATE BY APP'D

DESIGNED BY KH/DK	SCALE AS SHOWN
DRAWN BY DK/KK	DATE MAR. 26/99
CHECKED BY KH	CLIENT PROJECT NO.
F.S.C. FILE NO. C-2.DWG	F.S.C. JOB NO. 97-0170
SHEET	DRAWING NO.